


g:\Projects\2025\250281 - bridgeville town hall feasibility study\Drawings\working sets\C COVER PAGE.dwg, 3/23/2026 12:20 PM, Deane L. Townsend



VICINITY MAP  
N.T.S.

BRIDGEVILLE  
TOWN HALL

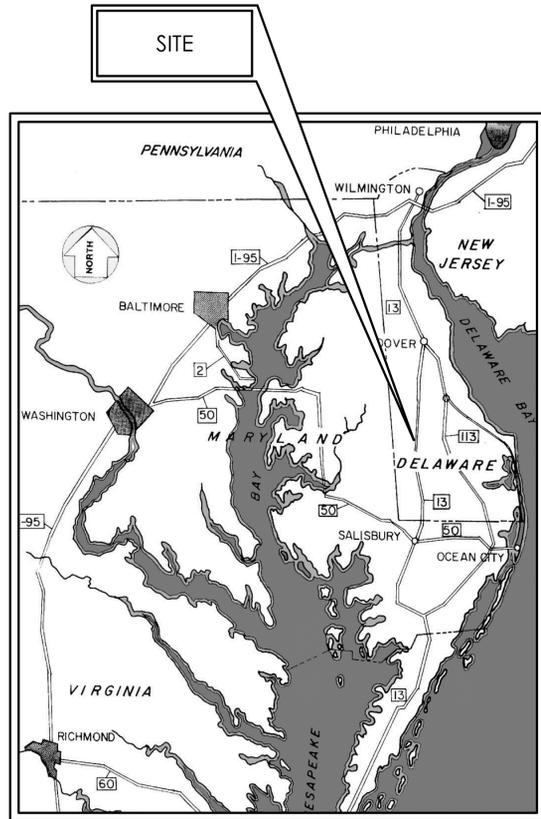

LOCATION MAP  
N.T.S.

# NEW ADDITION FOR: BRIDGEVILLE TOWN HALL

101 N MAIN STREET  
MILLSBORO, DE 19933



**CONTACTS:**

OWNER REP: TOWN OF BRIDGEVILLE  
101 N. MAIN STREET  
BRIDGEVILLE, DE 19933  
  
BETHANY DEBUSSY  
TOWN MANAGER  
  
ARCHITECT: GEORGE MILES & BUHR, LLC  
206 W. MAIN STREET  
SAUSBURY, MD 21801  
410-742-3115  
  
MORGAN HELFRICH, AIA LEED AP

**INDEX OF DRAWINGS:**

G1.0 COVER PAGE  
C1.0 CONCEPTUAL SITE EXHIBIT  
  
A0.1 EXISTING FOUNDATION PLAN  
A0.2 EXISTING FIRST FLOOR PLAN  
A0.3 EXISTING SECOND FLOOR PLAN  
A0.4 EXISTING ELEVATIONS  
  
A1.1 PROPOSED FIRST FLOOR PLAN  
A2.1 PROPOSED ELEVATIONS  
A2.2 PROPOSED ELEVATIONS


**GENERAL NOTES:**

- ALL WORK SHALL BE PERFORMED IN ACCORDANCE WITH THESE FINAL CONSTRUCTION DOCUMENTS. THE GENERAL CONTRACTOR SHALL VERIFY AND BE RESPONSIBLE FOR ALL FIELD DIMENSIONS, EXISTING CONDITIONS, AND PROJECT CONDITIONS, AND SHALL NOTIFY THE ARCHITECT OF ANY DISCREPANCIES, CONFLICTS, OR OMISSIONS THAT WOULD INTERFERE WITH THE SATISFACTORY COMPLETION OF THE PROJECT.
- BASE INFORMATION INDICATED ON THESE DRAWINGS WAS DERIVED FROM VISUAL OBSERVATIONS AS WELL AS EXISTING DRAWINGS, AND ALL DIMENSIONS ARE APPROXIMATE. THIS BASE INFORMATION IS PROVIDED FOR THE CONVENIENCE OF THE CONTRACTOR AND IS NOT TO BE CONSTRUED AS A RE-MEASURED OR "AS-BUILT" PLAN BY THE ARCHITECT, BUT RATHER AS REFERENCED DATA WHICH FROM ALL SURFACE APPEARANCES OBSERVED AT THE SITE IS BASICALLY ACCEPTABLE FOR THE PURPOSES OF THIS PROJECT.
- THE CONTRACTOR SHALL VERIFY ALL EXISTING CONDITIONS, ELEVATIONS, DIMENSIONS, BEFORE EXECUTION OF ANY WORK, AND, ANY VARIANCES OR INCONSISTENCIES SHALL BE BROUGHT TO THE ATTENTION OF THE ARCHITECT IMMEDIATELY AND IN WRITTEN FORM EITHER ON THE DRAWINGS OR IN A LETTER.
- THE CONTRACTOR AGREES TO WORK WITH THE ARCHITECT IN RESOLVING CONFLICTS IN A TIMELY MANNER, INCLUDING CONCEALED OR UNANTICIPATED CONDITIONS THAT AFFECT THE WORK OF THIS CONTRACT.
- ALL WORK SHALL BE PERFORMED IN ACCORDANCE WITH ALL LOCAL LAWS, ORDINANCES, RULES AND REGULATIONS OF THE GOVERNING AGENCIES HAVING JURISDICTION OVER THE PROJECT.
- THE CONTRACTOR MUST TAKE ADEQUATE CARE TO PROTECT ALL AREAS OF THE BUILDING WHERE THE WORK OF THIS ALTERATION IS LOCATED AS WELL AS AREAS ADJACENT TO THE AREA OF WORK OF THIS PROJECT SO AS TO PREVENT DAMAGE TO LIFE OR PROPERTY AS A RESULT OF THIS ALTERATION AND NEW CONSTRUCTION. PROVIDE ALL NECESSARY SAFEGUARDS, BARRICADES, FENCES, SIGNAGE, ETC. AS REQUIRED TO PROTECT THE OCCUPANTS, PUBLIC AND EMPLOYEES FROM ANY POSSIBLE INJURY RESULTING FROM THE WORK.
- IN ALL CASES, DRAWINGS SHALL NOT BE SCALED FOR INFORMATION. FIGURED DIMENSIONS SHALL GOVERN THE WORK AND ALL DIMENSIONS AND CONDITIONS MUST BE VERIFIED IN THE FIELD.
- THE CONTRACTOR AND EACH SUB-CONTRACTOR SHALL KEEP ACCURATE RECORDS OF ANY MODIFICATION OR DEVIATIONS FROM THE CONTRACT DOCUMENTS. THE CONTRACTOR SHALL DELIVER TO THE ARCHITECT A COMPLETE SET OF "AS-BUILT" DRAWINGS PRIOR TO APPROVAL OF FINAL PAYMENT.
- THE CONTRACTOR SHALL NOT MAKE, CAUSE TO BE MADE, OR PERMIT A SUBCONTRACTOR OR STAFF MEMBER OR LOCAL REPRESENTATIVE OF THE OWNER TO MAKE ANY CHANGES TO WHAT IS SPECIFIED ON THE DRAWINGS WITHOUT SPECIFIC AUTHORIZATION OF THE ARCHITECT.
- REPAIR OR REPLACE ALL AREAS DAMAGED AS A RESULT OF THE WORK TO THE SATISFACTION OF THE OWNER.

BRIDGEVILLE TOWN HALL International Building Code 2021 International Existing Building Code 2021 NFPA 101 - Life Safety Code 2021 Delaware Regulations: 702 Fire Protection in Building Construction		
TOPIC	DESCRIPTION	CODE REFERENCE
OCCUPANCY GROUP (NO CHANGE)	EXISTING TOWN HALL ADMIN. - BUSINESS (B) NEW COMMUNITY HALL - ASSEMBLY (A-3)	IBC 304.1 IBC 303.4 NFPA 6.1.2 and 6.1.11
ALTERATION CLASSIFICATION	LEVEL 2: WORK AREA LESS THAN 50% OF THE EXISTING BUILDING AREA RECONFIGURATION OF EXISTING SPACE FOR STORAGE, RESTROOMS, AND INCIDENTAL SPACES ADDITION: NEW 1520 SF COMMUNITY HALL	IEBC 604 IEBC 606
CONSTRUCTION CLASSIFICATION (NO CHANGE)	TYPE V-B, NONSPRINKLERED NFPA TYPE V D00	IBC TABLE 601 NFPA TABLE 8.2.1.2
ALLOWABLE AREAS	MAX. ALLOWABLE AREA NONSPRINKLERED EXISTING ADMIN. BUILDING, BASEMENT: EXISTING ADMIN. BUILDING, 1ST FLOOR: EXISTING ADMIN. BUILDING, 2ND FLOOR: NEW COUNCIL CHAMBERS ADDITION: TOTAL BUILDING AREA:	10,000 S.F. 320 S.F. 1,751 S.F. 1,751 S.F. 1,520 S.F. 5,342 S.F.
FIRE RESISTANCE BUILDING ELEMENTS	STRUCTURAL FRAME EXTERIOR BEARING WALLS INTERIOR BEARING WALLS NON-BEARING EXTERIOR WALLS NON-BEARING INTERIOR WALLS FLOORS ROOFS	0 HRS. 0 HRS. 0 HRS. 0 HRS. 0 HRS. 0 HRS.
SEPARATED OCCUPANCIES	SEPARATION B/W BUSINESS (B) AND ASSEMBLY (A-3) NONSPRINKLERED MIN. OPENING PROTECTIVES: DOORS WINDOWS	2 HOURS NFPA TABLE 6.1.14.4.1 IBC TABLE 716.1 NFPA TABLE 8.3.3.2.2 1 1/2 HOURS 2 HOURS
ENCLOSURE PROTECTION	STAIRWAYS TO PROVIDE MIN. ENCLOSURE OF 1 HOUR RATING WITH LESS THAN 4 STORIES IN HEIGHT. OPENINGS WITH MIN. 1 HR. RATING. ELEVATORS TO PROVIDE A MIN. ENCLOSURE OF 1 HOUR RATING WITH LESS THAN 4 STORIES IN HEIGHT. OPENINGS WITH MIN. 1 HR.	IBC 1023.2 IBC TABLE 716.1(2) NFPA 6.5 IBC 713.4
AUTOMATIC SPRINKLERS	SINGLE OCCUPANT, MIXED USE BUILDING. RECONFIGURATION OF EXIST. LESS THAN 50%, AND UNDER 10,000 SF. SPRINKLERS NOT REQ'D.	IEBC 803.2.2 DE 702, CH 4-1.2
MAX. AREA UNPROTECTED OPENING	EXTERIOR WALLS > 30 FT. = NEW OPENINGS (NOT PROTECTED) (EXISTING OPENINGS NOT PROTECTED)	NOT REQ'D IBC TABLE 705.8
WALL AND CEILING FINISH	BUILDING EXIT ENCLOSURE ROOMS CORRIDORS	CLASS A CLASS A CLASS C
OCCUPANT LOAD	EXIST. ADMIN. BASEMENT (GROSS): 320 S.F. / 150 = EXIST. ADMIN. 1ST (GROSS): 1,751 S.F. / 150 = EXIST. ADMIN. 2ND (GROSS): 1,751 S.F. / 150 = NEW COUNCIL CHAMBERS (NET): 1520 S.F. / 115 = TOTAL ADMIN. BUILDING PERSONS:	2 OCC. 12 OCC. 12 OCC. 101 OCC. 127 OCC.

BRIDGEVILLE TOWN HALL International Building Code 2021 International Existing Building Code 2021 NFPA 101 - Life Safety Code 2021 Delaware Regulations: 702 Fire Protection in Building Construction		
TOPIC	DESCRIPTION	CODE REFERENCE
EGRESS WIDTH	EXITS: 0.2 x 192 = 38.4 INCHES PROVIDED: EXIST. 3, 36 INCHES = 108"	IBC 1005.3.2 NFPA TABLE 7.3.3.1
EXIT ACCESS TRAVEL DISTANCE	ASSEMBLY (A) + BUSINESS (B) = 200 FT. NONSPRINKLERED COMMON PATH (B, <30 OCCUPANTS) = 75 FT. NONSPRINKLERED COMMON PATH (A, >50 OCCUPANTS) = 20 FT. NONSPRINKLERED	IBC TABLE 1017.2 NFPA TABLE 4.7.6 IBC TABLE 1006.2.1
CORRIDOR REQUIREMENTS	CORRIDOR WALLS AND OPENINGS (>30 OCCUPANTS): 1 HR. DEAD END CORRIDOR LENGTH: 20 FT. MAX.	IBC 1020.2 NFPA 12.3.6 + 38.3.6 NFPA 4.7.6
STAIRWAY ENCLOSURE	EXISTING STAIRS TO BE ENCLOSED. ENCLOSURE TO OFFER MIN. 1 HOUR RATING WITH MIN. 1 HOUR RATED OPENINGS	IBC 802.2.3 NFPA 7.2.2.5.1.3 NFPA 7.1.3.2.1(1)
ELEVATOR REQUIREMENTS	ELEVATOR NOT REQUIRED. RECONFIGURATION OF EXISTING THREE STORY STRUCTURE LESS THAN 50% OF AREA AND LIMITED TO SINGLE FLOOR	IBC 1104.4, EXC. 1.4 DE AAB 4.1.6 (1) (c)
PLUMBING FIXTURES	EXIST. ADMIN. BUILDING: 26 B OCCUPANTS / 2 = 13 M & 13 F WATER CLOSETS: 1 PER 25 FOR FIRST 50, AND 1 PER 50 THEREAFTER REQUIRED = 13 / 25 = 1 M & 1 F PROVIDED = 2 M & 2 F + 1 EXIST. UNISEX  LAVATORIES: 1 PER 40 FOR THE FIRST 80, AND 1 PER 80 THEREAFTER REQUIRED = 13 / 40 = 1 M & 1 F PROVIDED = 1 M & 2 F + 1 UNISEX  NEW COUNCIL CHAMBER ADDITION: 101 A-3 OCC. / 2 = 51 M & 51 F WATER CLOSETS: 1 PER 125 M, 1 PER 65 F REQUIRED = 84 / 125 = 1 M and 84 / 65 = 2 F PROVIDED = 2 M & 2 F + 1 UNISEX  LAVATORIES: 1 PER 200 REQUIRED = 84 / 200 = 1 M & 1 F PROVIDED = 1 M & 2 F + 1 UNISEX  1 WATER COOLER, 1 NEW D.F. PROVIDED 1 SERVICE SINK, EXISTING	IBC TABLE 2902.1
THERMAL PERFORMANCE REQUIREMENTS	ZONE 4, EXCEPT MARINE ROOF: ATTIC AND OTHER WALL: MASS WALL: WOOD FRAMED: FLOOR - JOIST FRAMED:  FIXED FENESTRATION: OPERABLE FENESTRATION: ENTRANCE DOORS:	R-49 R-9.5 CI R-20 R-30  U-0.36 U-0.45 U-0.68
		IECC C402.1.3

DATE	02-09-2026	REVISION	ISSUED FOR PERMIT	NO.	1
<b>GEORGE MILES &amp; BUHR, LLC</b> ARCHITECTS & ENGINEERS SAUSBURY • BALTIMORE • SEAFORD www.gmbnet.com					
FEASIBILITY STUDY FOR: <b>BRIDGEVILLE TOWN HALL</b> 101 N MAIN STREET BRIDGEVILLE, DE 19933					
COVER PAGE					
SCALE : --- DESIGN BY : MHH DRAWN BY : JDM CHECKED BY : DLT GMB FILE : 250281 DATE : 3/23/2026					
G1.0					

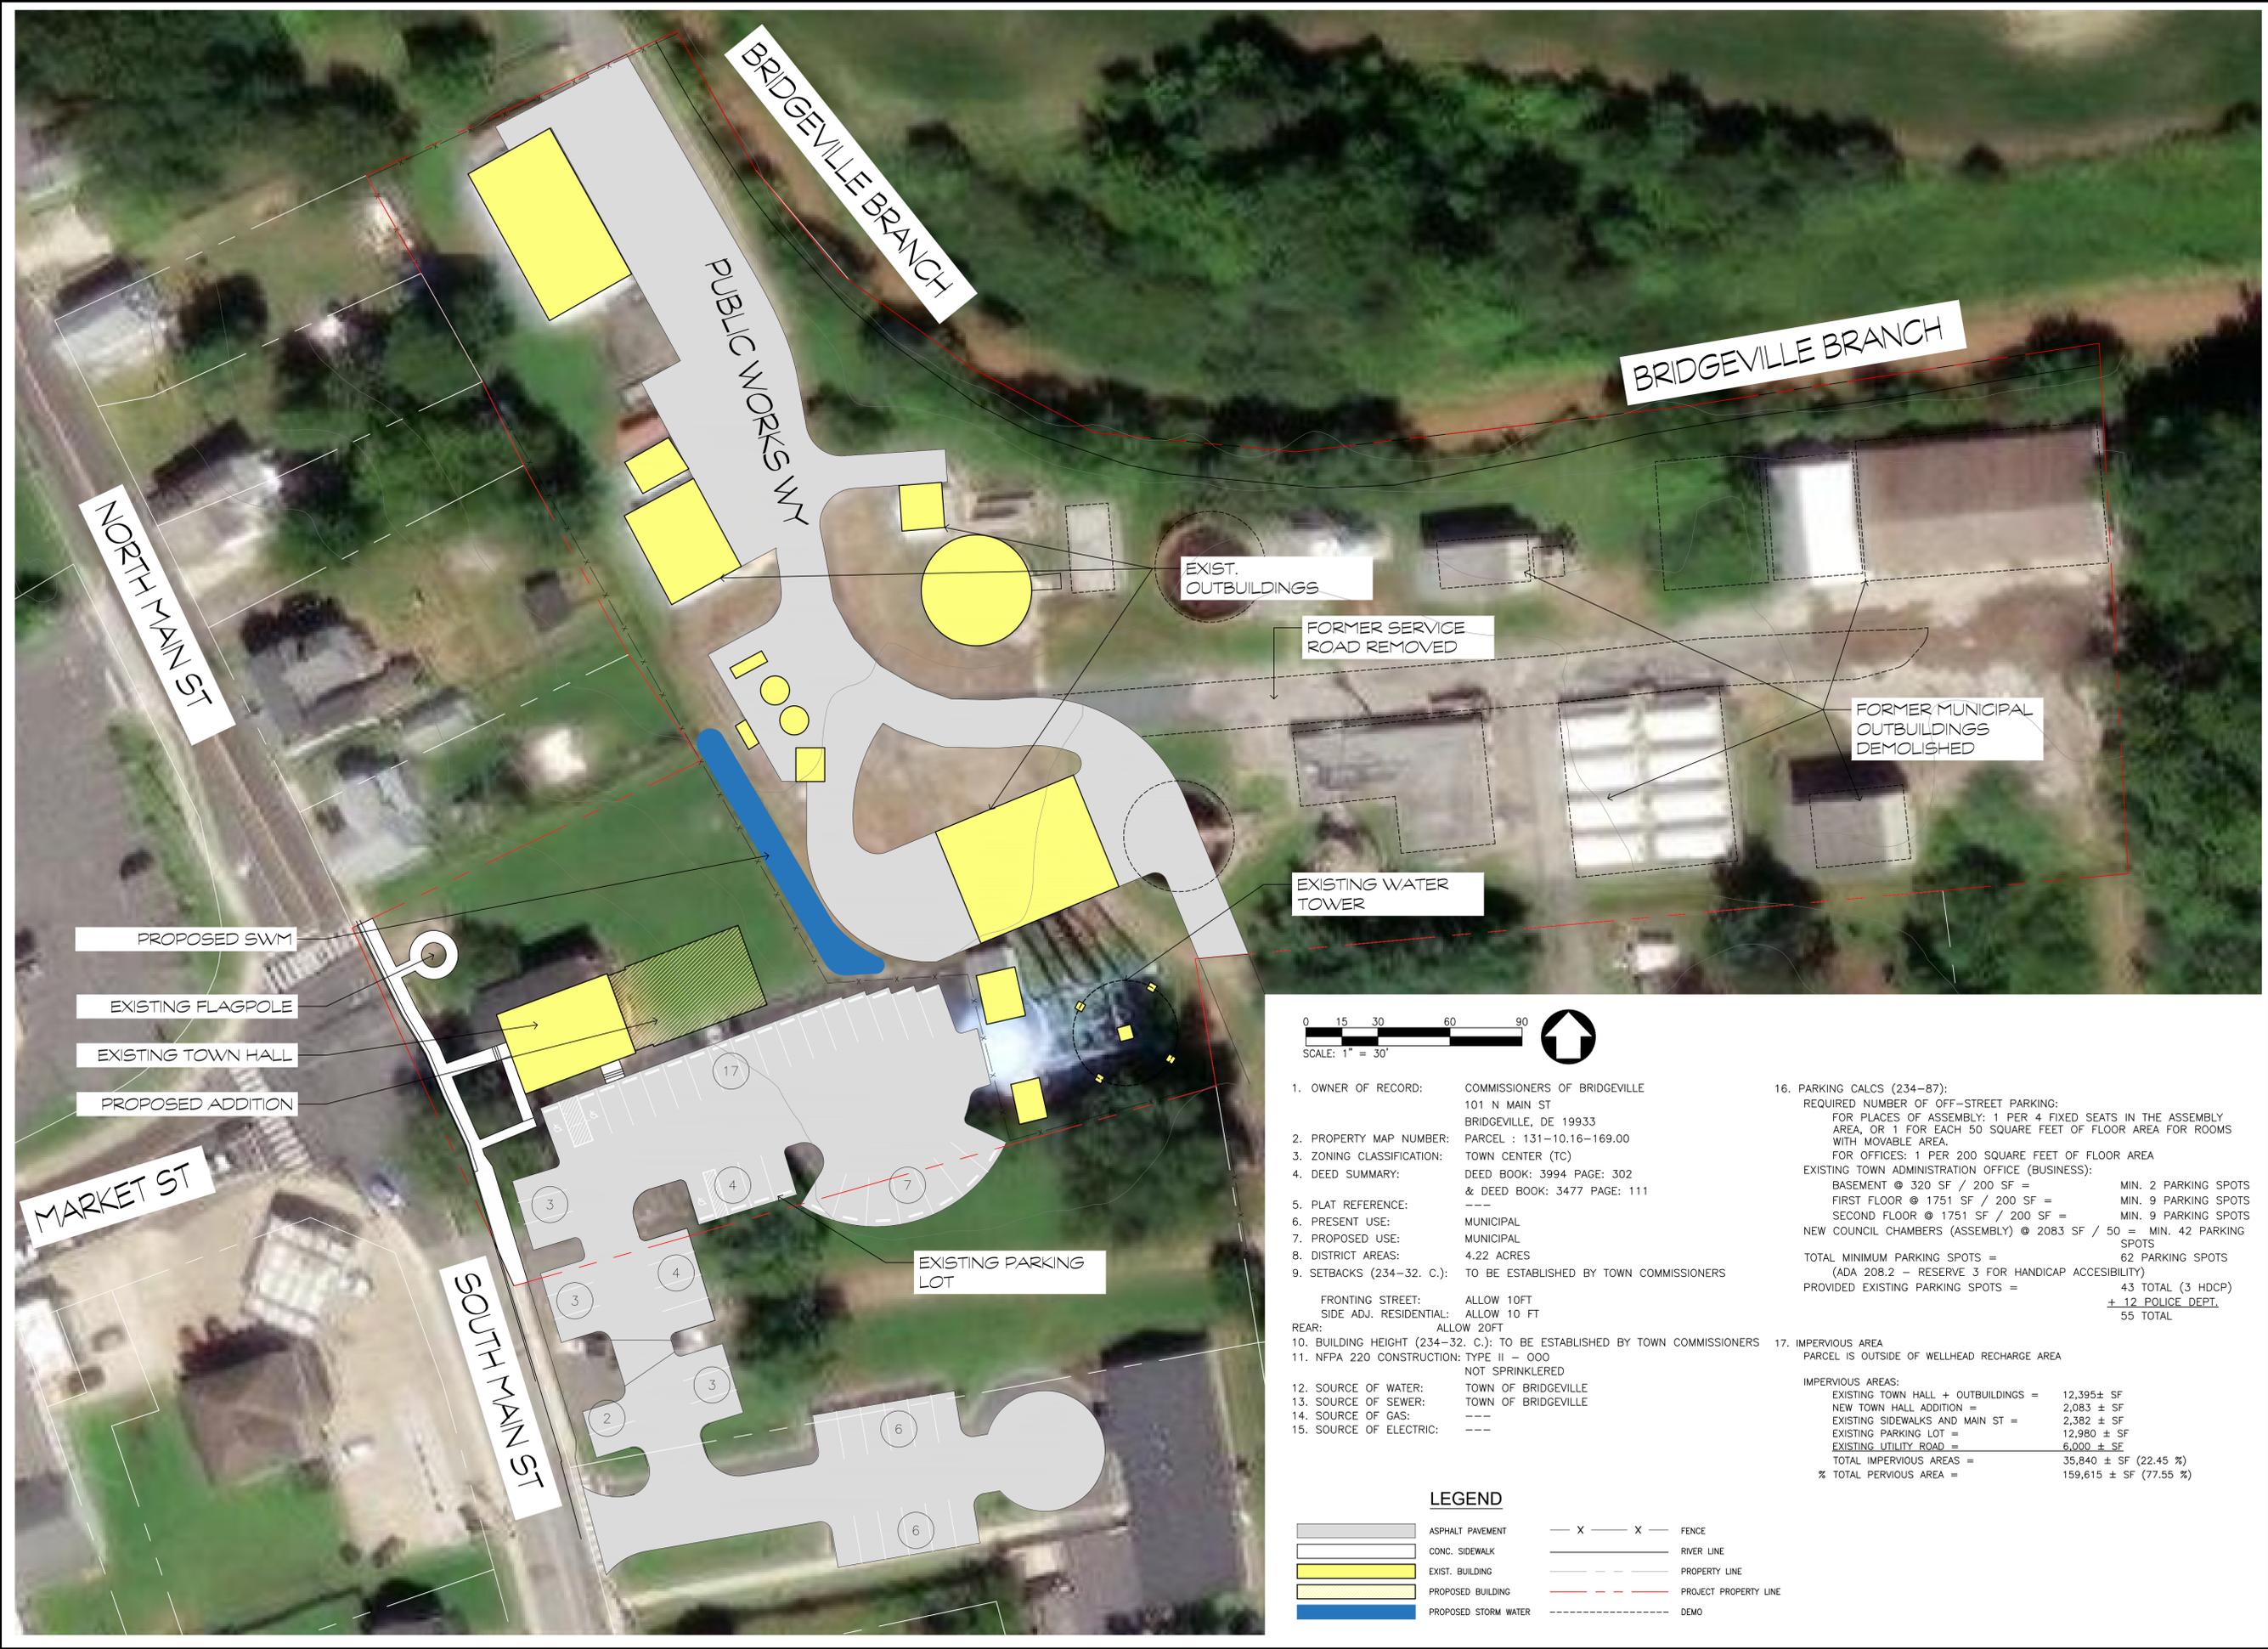

- PROPOSED SWM
- EXISTING FLAGPOLE
- EXISTING TOWN HALL
- PROPOSED ADDITION

 
EXIST. OUTBUILDINGS

FORMER SERVICE ROAD REMOVED

FORMER MUNICIPAL OUTBUILDINGS DEMOLISHED

EXISTING WATER TOWER

EXISTING PARKING LOT



1. OWNER OF RECORD: COMMISSIONERS OF BRIDGEVILLE  
101 N MAIN ST  
BRIDGEVILLE, DE 19933
2. PROPERTY MAP NUMBER: PARCEL : 131-10.16-169.00
3. ZONING CLASSIFICATION: TOWN CENTER (TC)
4. DEED SUMMARY: DEED BOOK: 3994 PAGE: 302 & DEED BOOK: 3477 PAGE: 111
5. PLAT REFERENCE: ---
6. PRESENT USE: MUNICIPAL
7. PROPOSED USE: MUNICIPAL
8. DISTRICT AREAS: 4.22 ACRES
9. SETBACKS (234-32. C.): TO BE ESTABLISHED BY TOWN COMMISSIONERS
- FRONTING STREET: ALLOW 10FT  
SIDE ADJ. RESIDENTIAL: ALLOW 10 FT  
REAR: ALLOW 20FT
10. BUILDING HEIGHT (234-32. C.): TO BE ESTABLISHED BY TOWN COMMISSIONERS
11. NFPA 220 CONSTRUCTION: TYPE II - 000 NOT SPRINKLERED
12. SOURCE OF WATER: TOWN OF BRIDGEVILLE
13. SOURCE OF SEWER: TOWN OF BRIDGEVILLE
14. SOURCE OF GAS: ---
15. SOURCE OF ELECTRIC: ---


16. PARKING CALCS (234-87):  
REQUIRED NUMBER OF OFF-STREET PARKING:  
FOR PLACES OF ASSEMBLY: 1 PER 4 FIXED SEATS IN THE ASSEMBLY AREA, OR 1 FOR EACH 50 SQUARE FEET OF FLOOR AREA FOR ROOMS WITH MOVABLE AREA.  
FOR OFFICES: 1 PER 200 SQUARE FEET OF FLOOR AREA
- EXISTING TOWN ADMINISTRATION OFFICE (BUSINESS):  
BASEMENT @ 320 SF / 200 SF = MIN. 2 PARKING SPOTS  
FIRST FLOOR @ 1751 SF / 200 SF = MIN. 9 PARKING SPOTS  
SECOND FLOOR @ 1751 SF / 200 SF = MIN. 9 PARKING SPOTS  
NEW COUNCIL CHAMBERS (ASSEMBLY) @ 2083 SF / 50 = MIN. 42 PARKING SPOTS
- TOTAL MINIMUM PARKING SPOTS = 62 PARKING SPOTS  
(ADA 208.2 - RESERVE 3 FOR HANDICAP ACCESSIBILITY)
- PROVIDED EXISTING PARKING SPOTS = 43 TOTAL (3 HDPCP) + 12 POLICE DEPT. = 55 TOTAL

**LEGEND**

- |  |                      |  |                       |
|--|----------------------|--|-----------------------|
|  | ASPHALT PAVEMENT     |  | FENCE                 |
|  | CONC. SIDEWALK       |  | RIVER LINE            |
|  | EXIST. BUILDING      |  | PROPERTY LINE         |
|  | PROPOSED BUILDING    |  | PROJECT PROPERTY LINE |
|  | PROPOSED STORM WATER |  | DEMO                  |

17. IMPERVIOUS AREA  
PARCEL IS OUTSIDE OF WELLHEAD RECHARGE AREA
- IMPERVIOUS AREAS:  
EXISTING TOWN HALL + OUTBUILDINGS = 12,395 ± SF  
NEW TOWN HALL ADDITION = 2,083 ± SF  
EXISTING SIDEWALKS AND MAIN ST = 2,382 ± SF  
EXISTING PARKING LOT = 12,980 ± SF  
EXISTING UTILITY ROAD = 6,000 ± SF  
TOTAL IMPERVIOUS AREAS = 35,840 ± SF (22.45 %)  
% TOTAL PERVIOUS AREA = 159,615 ± SF (77.55 %)

NO.	1	REVISION	ISSUED FOR PERMIT	DATE	02-09-2026
<b>FEASIBILITY STUDY FOR:</b> <b>BRIDGEVILLE TOWN HALL</b> 101 N MAIN STREET BRIDGEVILLE, DE 19933					
CONCEPTUAL SITE EXHIBIT					
SCALE : 1/4" = 1'-0" DESIGN BY : MHH DRAWN BY : JDM CHECKED BY : MHH GMB FILE : 250281 DATE : 3/23/2026					
C1.0					

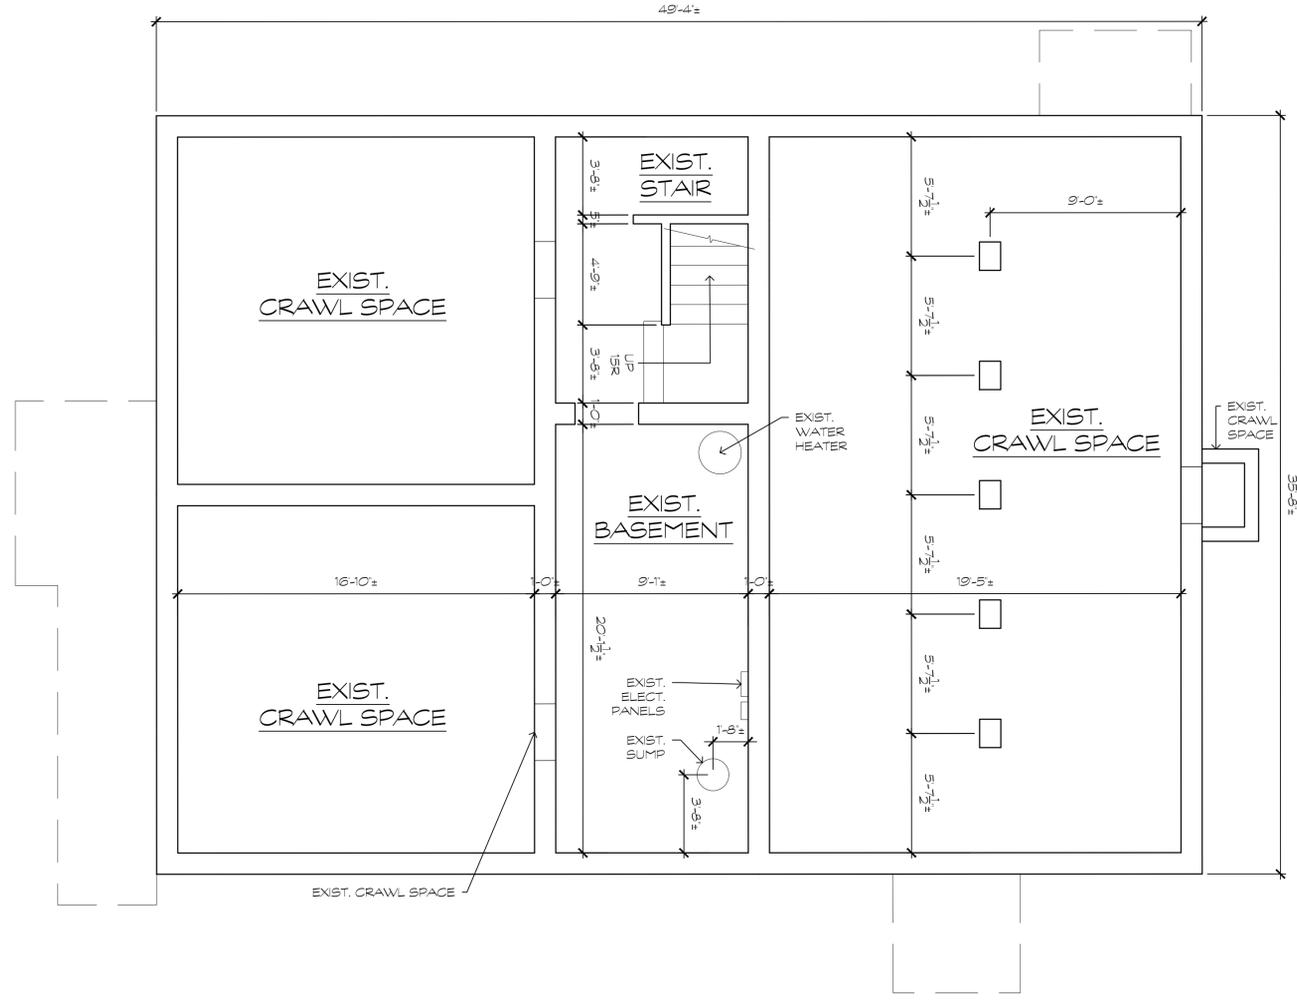

1

**EXISTING BASEMENT/FOUNDATION PLAN**  
1/4" = 1'-0"



SCALE	: 1/4" = 1'-0"
DESIGN BY	: MHH
DRAWN BY	: JDM
CHECKED BY	: MHH
GMB FILE	: 250281
DATE	: 3/23/2026

**AO.1**


**EXISTING FOUNDATION PLAN**

**FEASIBILITY STUDY FOR:  
BRIDGEVILLE TOWN HALL**  
101 N MAIN STREET BRIDGEVILLE, DE 19333

**GMB**  
GEORGE, MILES & BUHR, LLC  
ARCHITECTS & ENGINEERS  
SAUSBURY • BALTIMORE • SEAFORD  
www.gmbnet.com

NO.	REVISION	DATE
1	ISSUED FOR PERMIT	02-09-2026


g:\Projects\2025\250281\_bridgville\_town\_hall\_feasibility\_study\Drawings\working\_sets\A1.0\_EXISTING\_CONDITIONS.dwg, 3/23/2026 12:21 PM, Deane L. Townsend

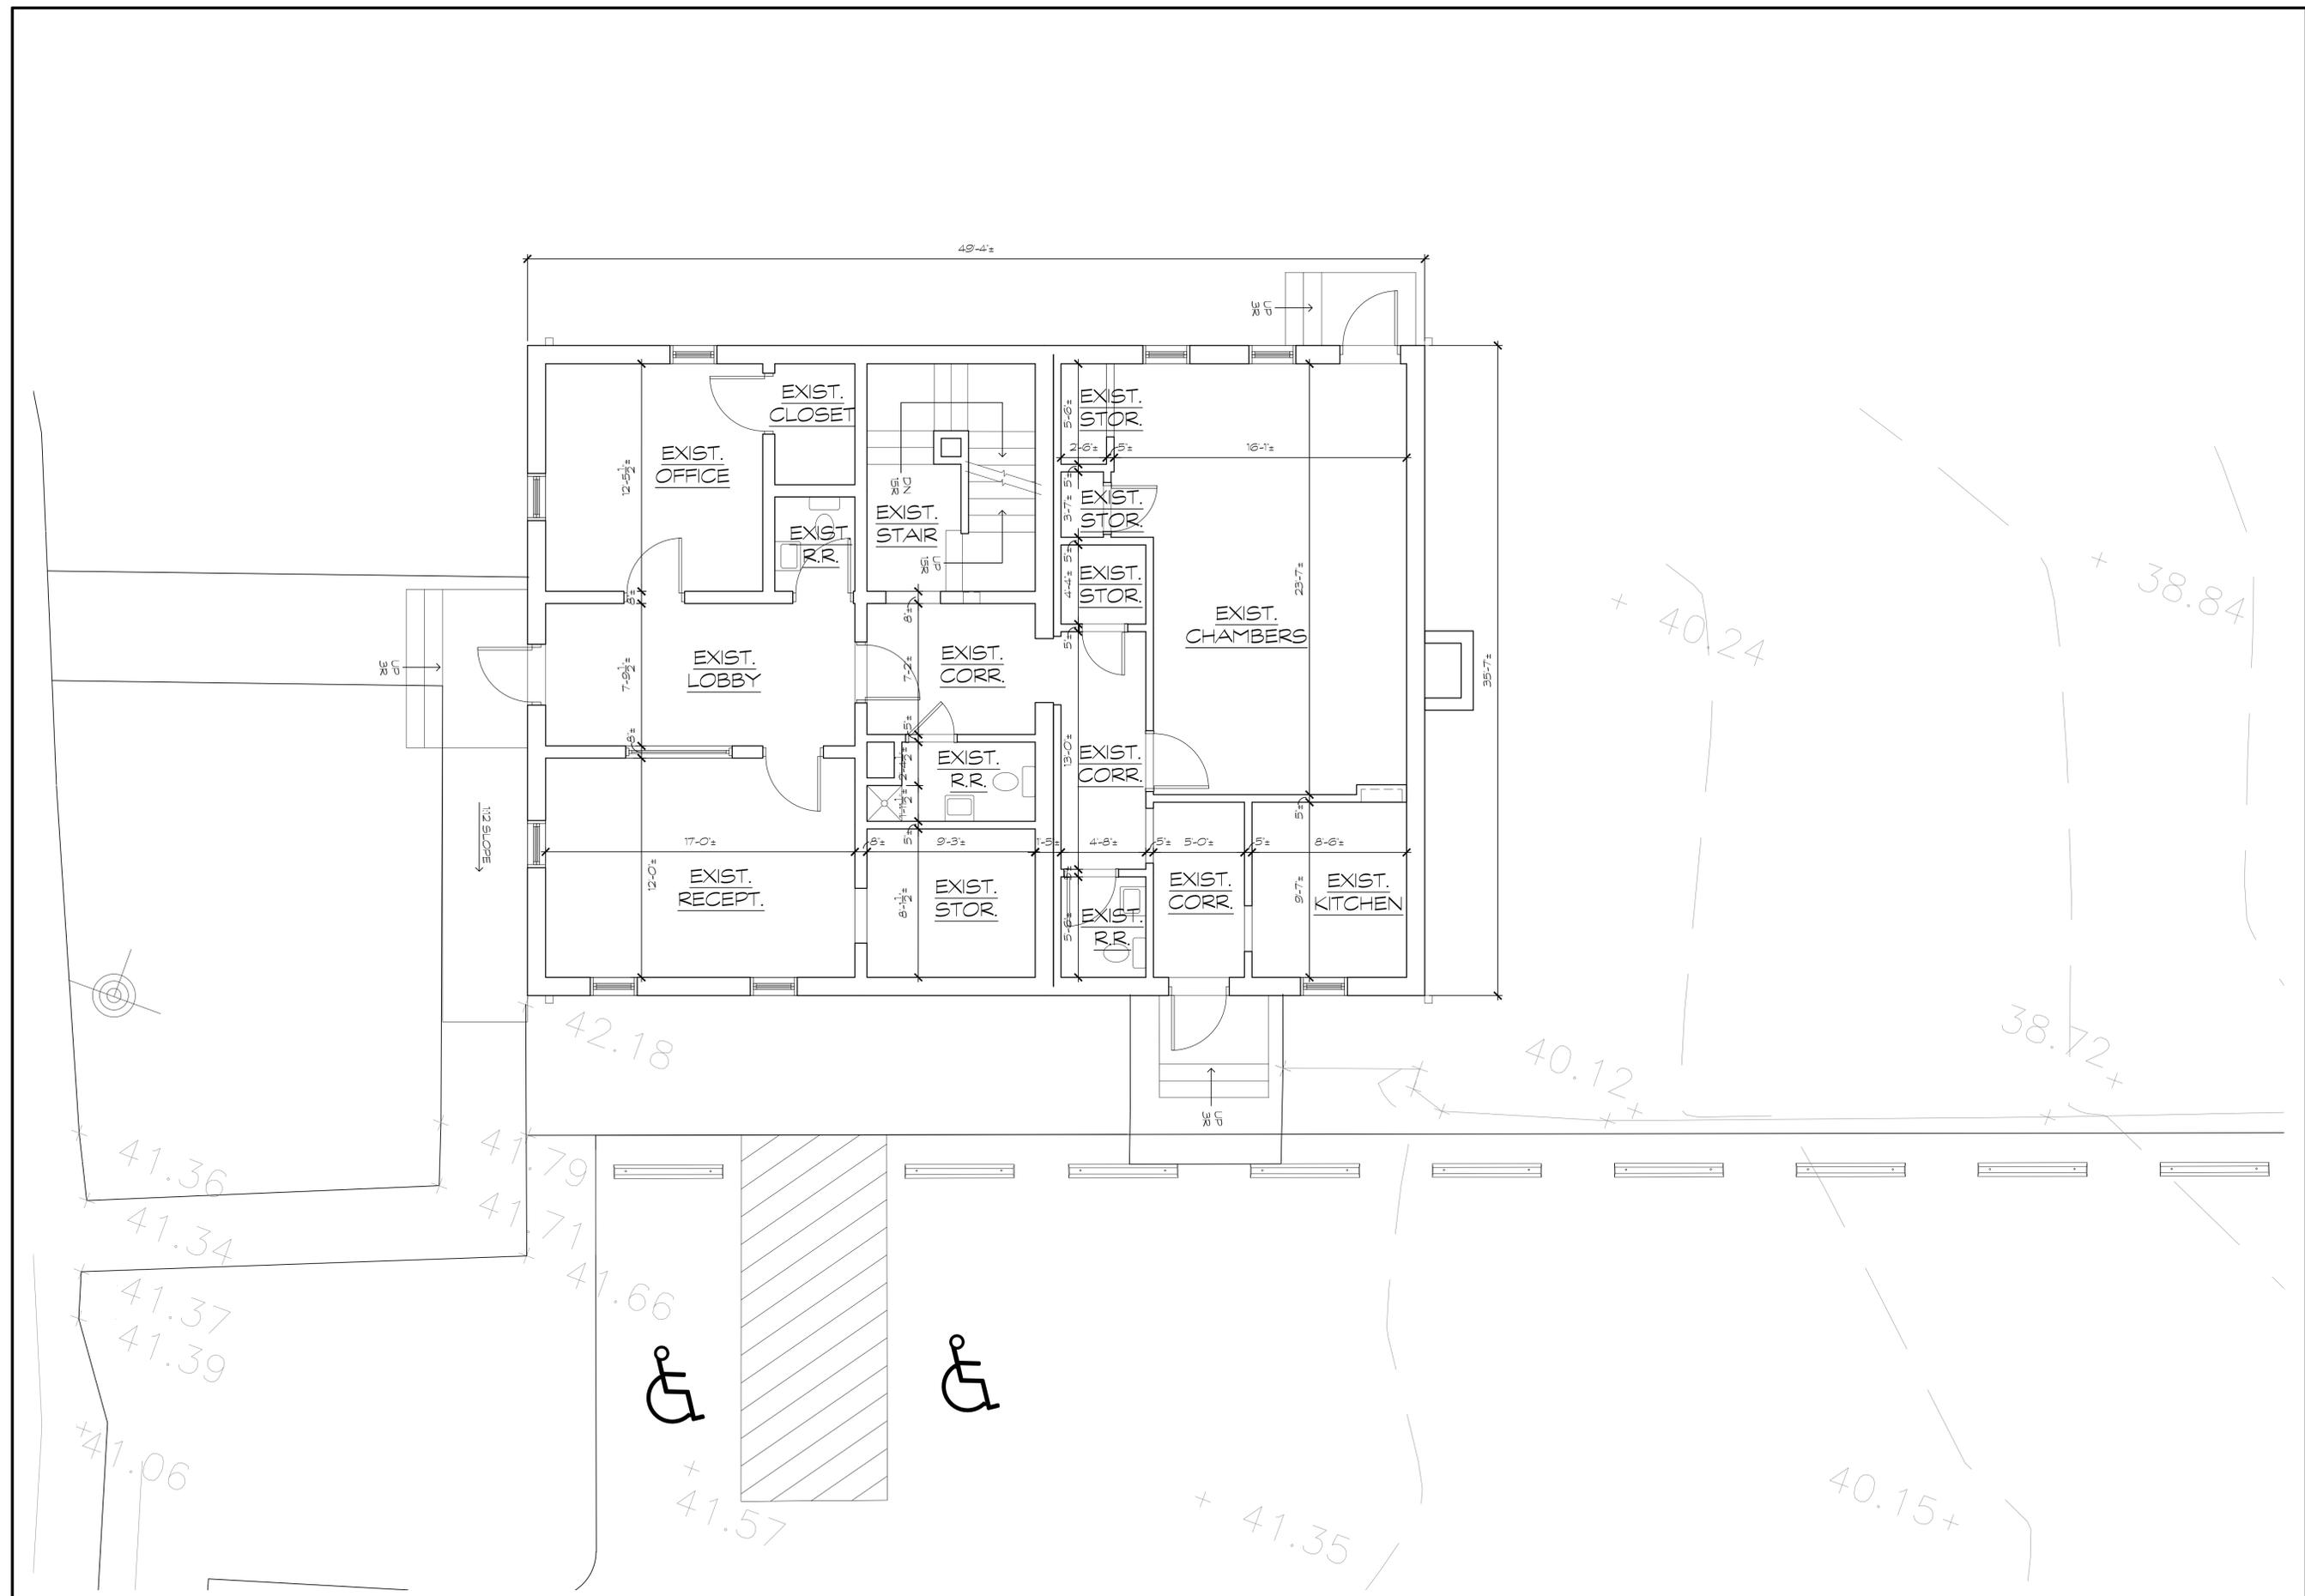

1 EXISTING FIRST FLOOR PLAN  
1/4" = 1'-0"



<p><b>GMB</b> GEORGE, MILES &amp; BUHR, LLC ARCHITECTS &amp; ENGINEERS SAUSBURY • BALTIMORE • SEAFORD www.gmbnet.com</p>	
<p>FEASIBILITY STUDY FOR: <b>BRIDGEVILLE TOWN HALL</b> 101 N MAIN STREET BRIDGEVILLE, DE 19933</p>	
<p>EXISTING FIRST FLOOR PLAN</p>	
SCALE	: 1/4" = 1'-0"
DESIGN BY	: LKW
DRAWN BY	: JDM
CHECKED BY	: MHH
GMB FILE	: 250281
DATE	: 3/23/2026
NO.	
REVISION	
DATE	
<p><b>A0.2</b></p>	

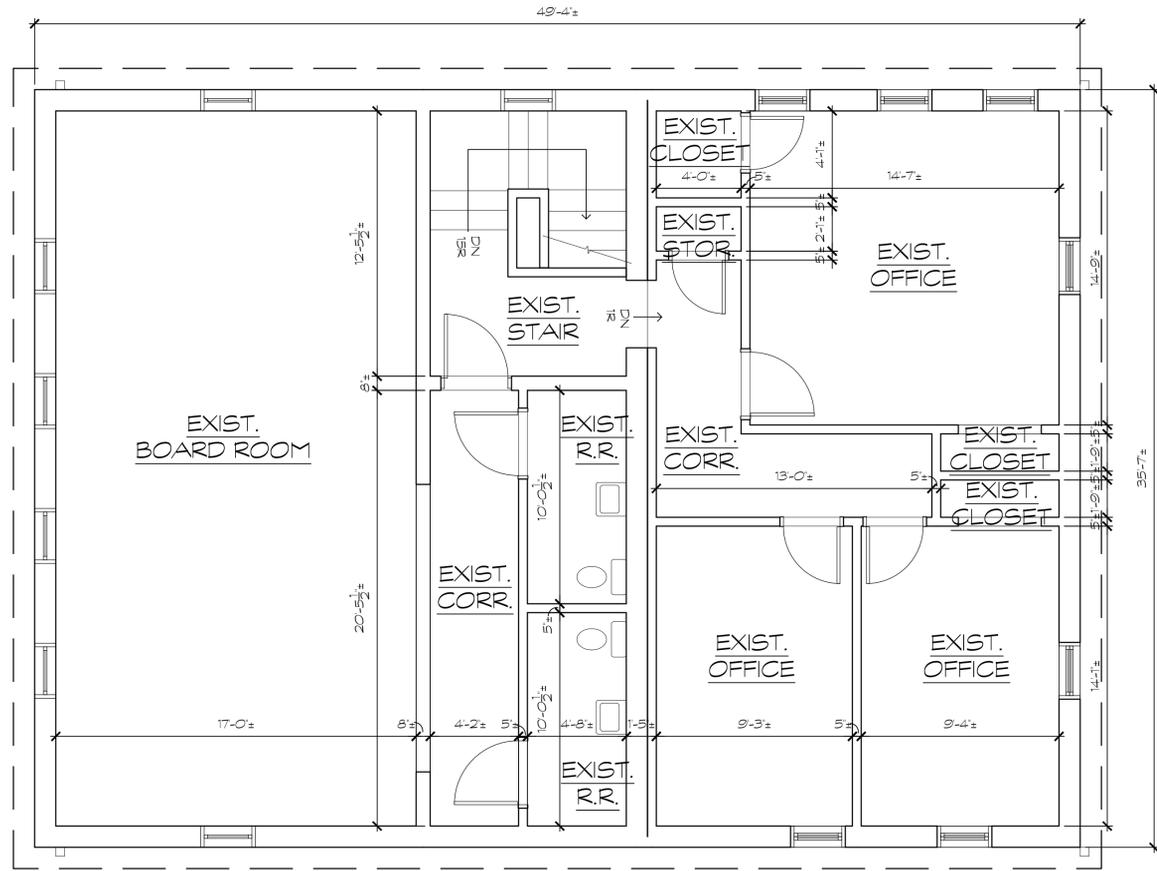

1

EXISTING SECOND FLOOR PLAN  
1/4" = 1'-0"



SCALE : 1/4" = 1'-0"  
DESIGN BY : MHH  
DRAWN BY : JDM  
CHECKED BY : MHH  
GMB FILE : 250281  
DATE : 3/23/2026


A0.3

FEASIBILITY STUDY FOR:  
**BRIDGEVILLE TOWN HALL**  
101 N MAIN STREET BRIDGEVILLE, DE 19933




NO.	REVISION	DATE
1	ISSUED FOR PERMIT	02-09-2026


g:\Projects\2025\250281\_bridgetown\_hall\_feasibility\_study\Drawings\working\_sets\A2.1\_ELEVATIONS.dwg, 3/23/2026 12:21 PM, Deane L. Townsend

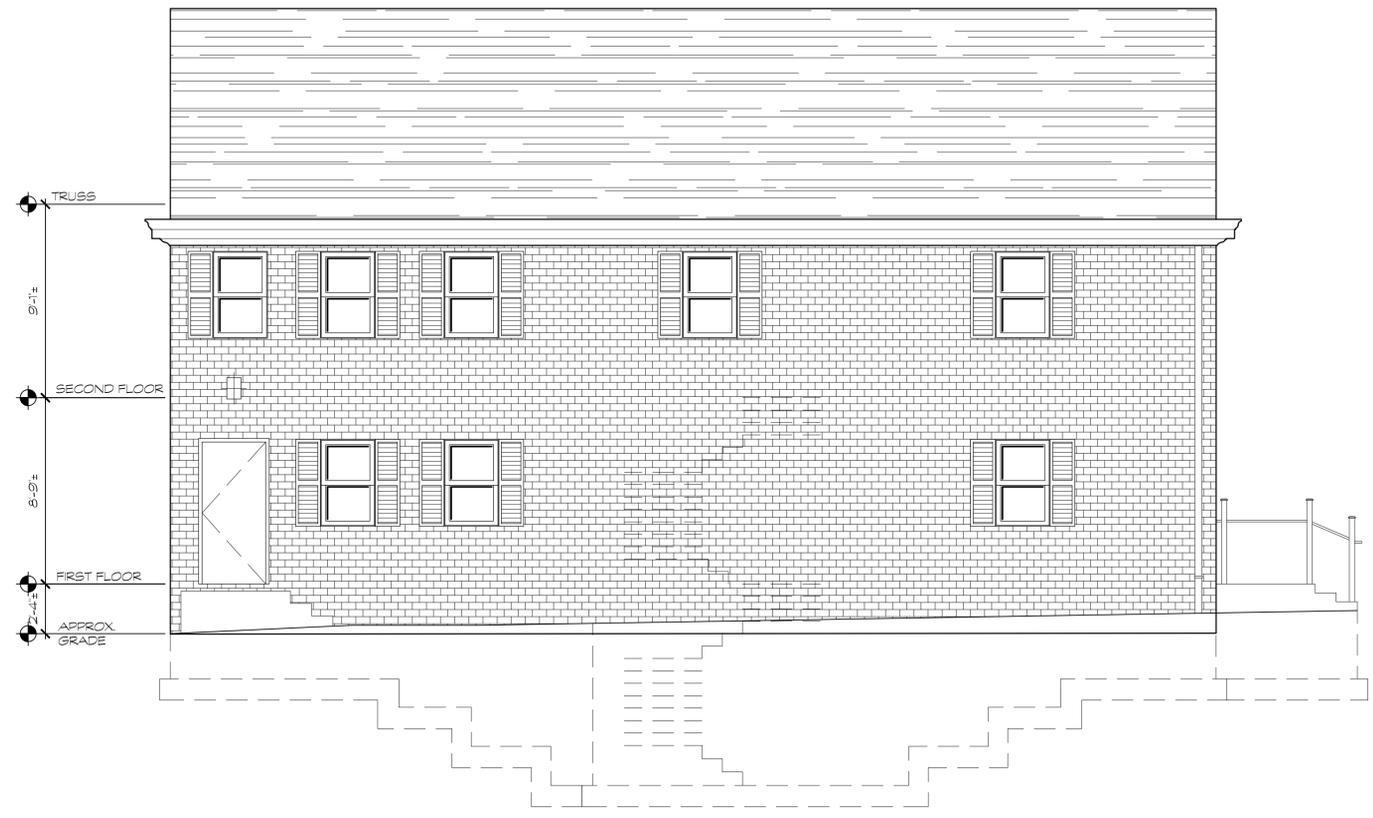

**1** NORTH ELEVATION  
1/4" = 1'-0"

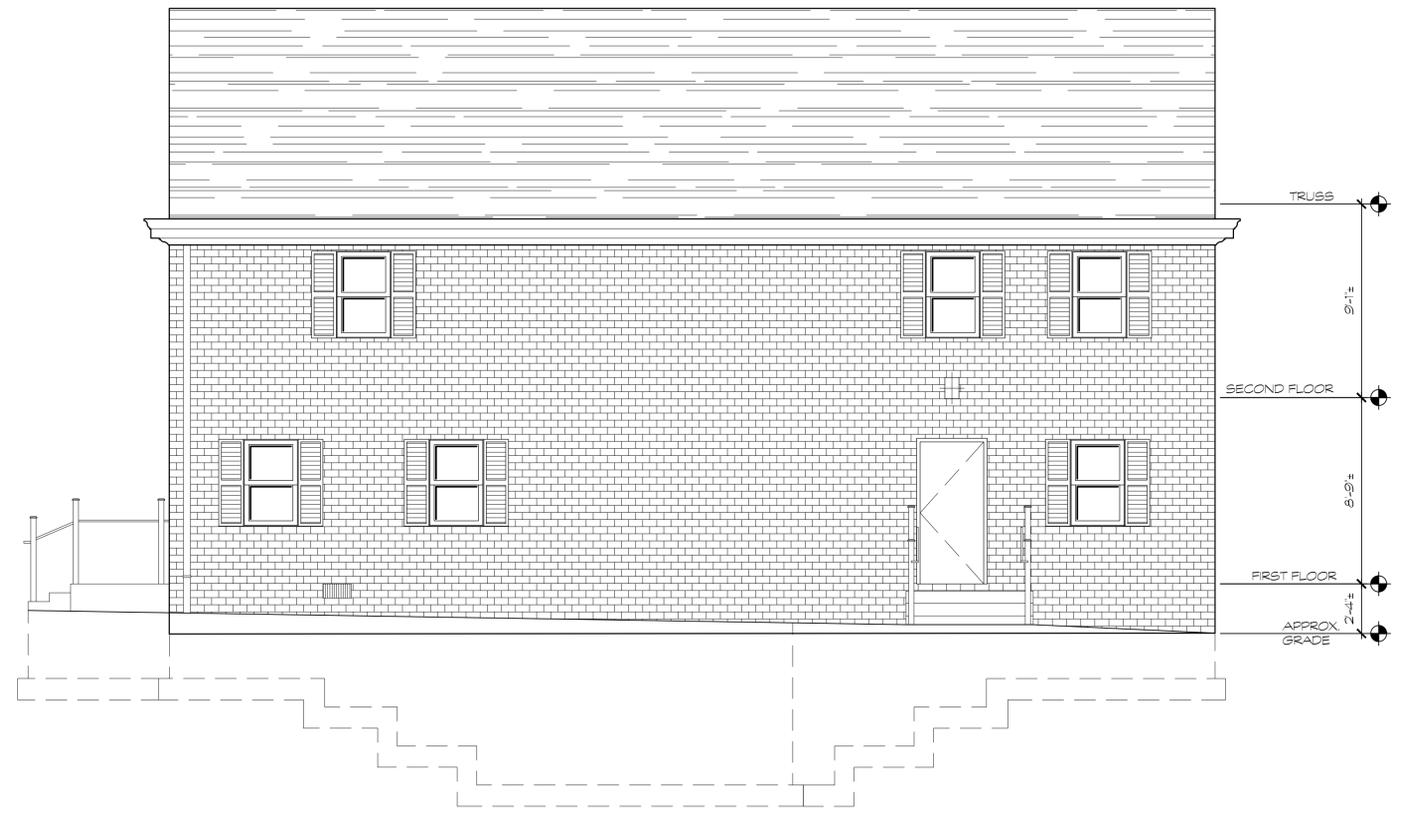


**3** SOUTH ELEVATION  
1/4" = 1'-0"

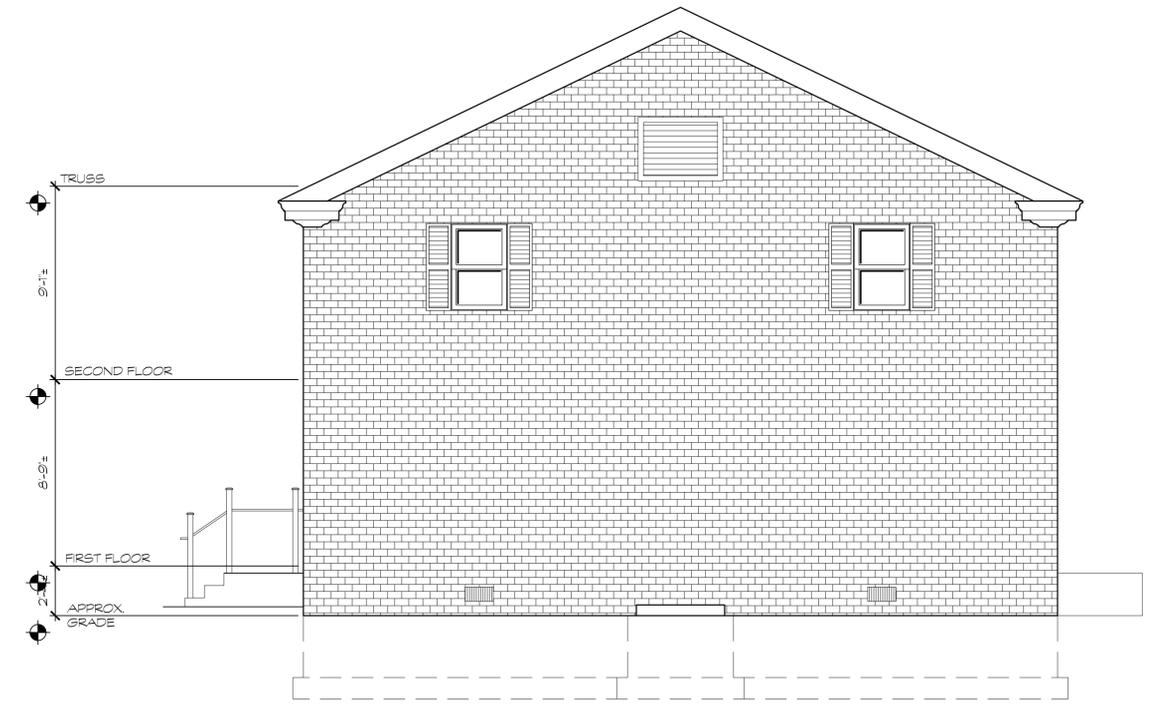

**2** EAST ELEVATION  
1/4" = 1'-0"

NO.	REVISION	DATE
 <b>GMB</b> GEORGE, MILES & BUHR, LLC ARCHITECTS & ENGINEERS SAUSBURY • BALTIMORE • SEAFORD <a href="http://www.gmbnet.com">www.gmbnet.com</a>		
FEASIBILITY STUDY FOR <b>BRIDGEVILLE TOWN HALL</b> 101 N MAIN STREET BRIDGEVILLE, DE 19933		
<b>EXISTING ELEVATIONS</b>		
SCALE : 1/4" = 1'-0" DESIGN BY : MHH DRAWN BY : JDM CHECKED BY : MHH GMB FILE : 250281 DATE : 3/23/2026		
A0.4		
© COPYRIGHT 2025 GEORGE, MILES & BUHR, LLC		

g:\Projects\2025\250281\_bridgetown\_hall\_feasibility\_study\Drawings\working sets\A.1 FIRST FLOOR PLAN.dwg, 3/23/2026 12:21 PM, Deane L. Townsend

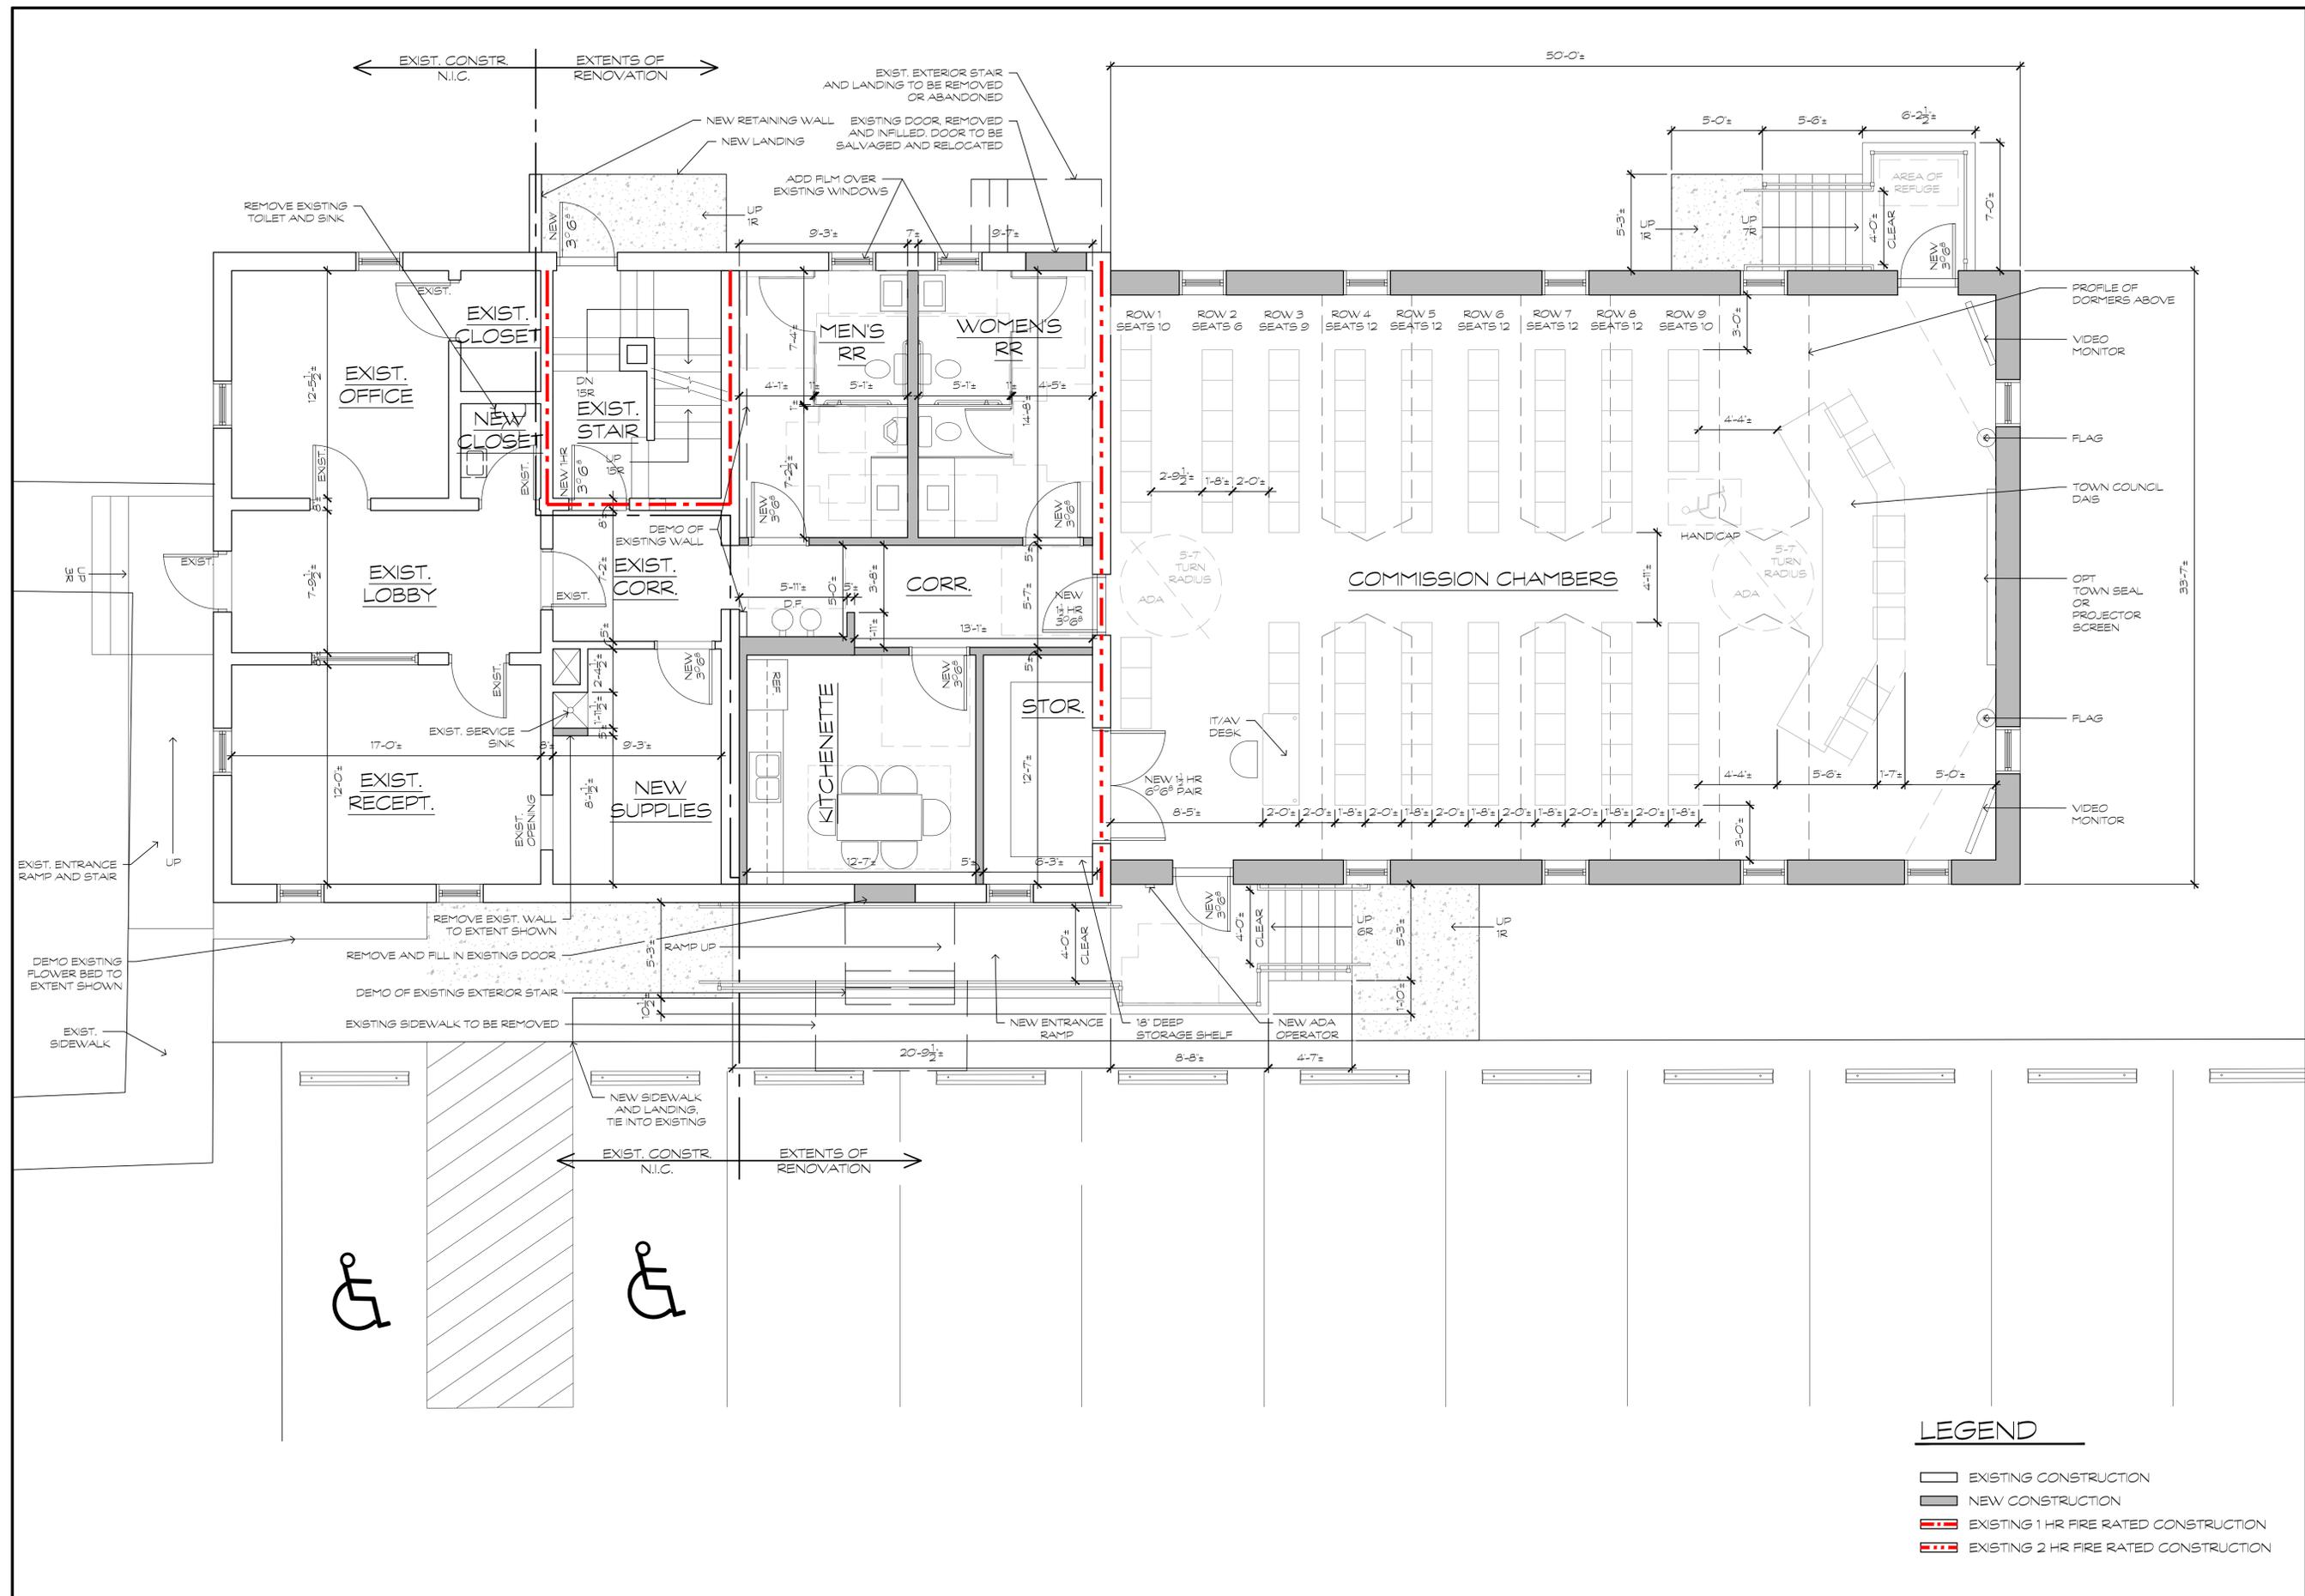

- LEGEND**
- EXISTING CONSTRUCTION
  - NEW CONSTRUCTION
  - EXISTING 1 HR FIRE RATED CONSTRUCTION
  - EXISTING 2 HR FIRE RATED CONSTRUCTION

**1** FIRST FLOOR PLAN (EXIST. 1751 SF + NEW 1695 SF ADDITION; TOTAL 3,446 SF FOOTPRINT); SEATS 95 GUESTS  
1/4" = 1'-0"




NO.	1	REVISION	ISSUED FOR PERMIT	DATE	02-09-2026
<b>GMB</b> GEORGE, MILES & BUHR, LLC ARCHITECTS & ENGINEERS SALESBURY • BALTIMORE • SEAFORD www.gmbnet.com					
<b>FEASIBILITY STUDY FOR:</b> <b>BRIDGEVILLE TOWN HALL</b> 101 N MAIN STREET BRIDGEVILLE, DE 19933					
<b>PROPOSED FIRST FLOOR PLAN</b>					
SCALE : AS NOTED DESIGN BY : MHH DRAWN BY : JDM CHECKED BY : DLT GMB FILE : 250281 DATE : 3/23/2026					
A1.1					

g:\Projects\2025\250281\_bridgetown hall feasibility study\Drawings\working sets\A2.1 ELEVATIONS A.dwg, 3/23/2026 12:20 PM, Deane L. Townsend



1 NORTH ELEVATION  
1/4" = 1'-0"

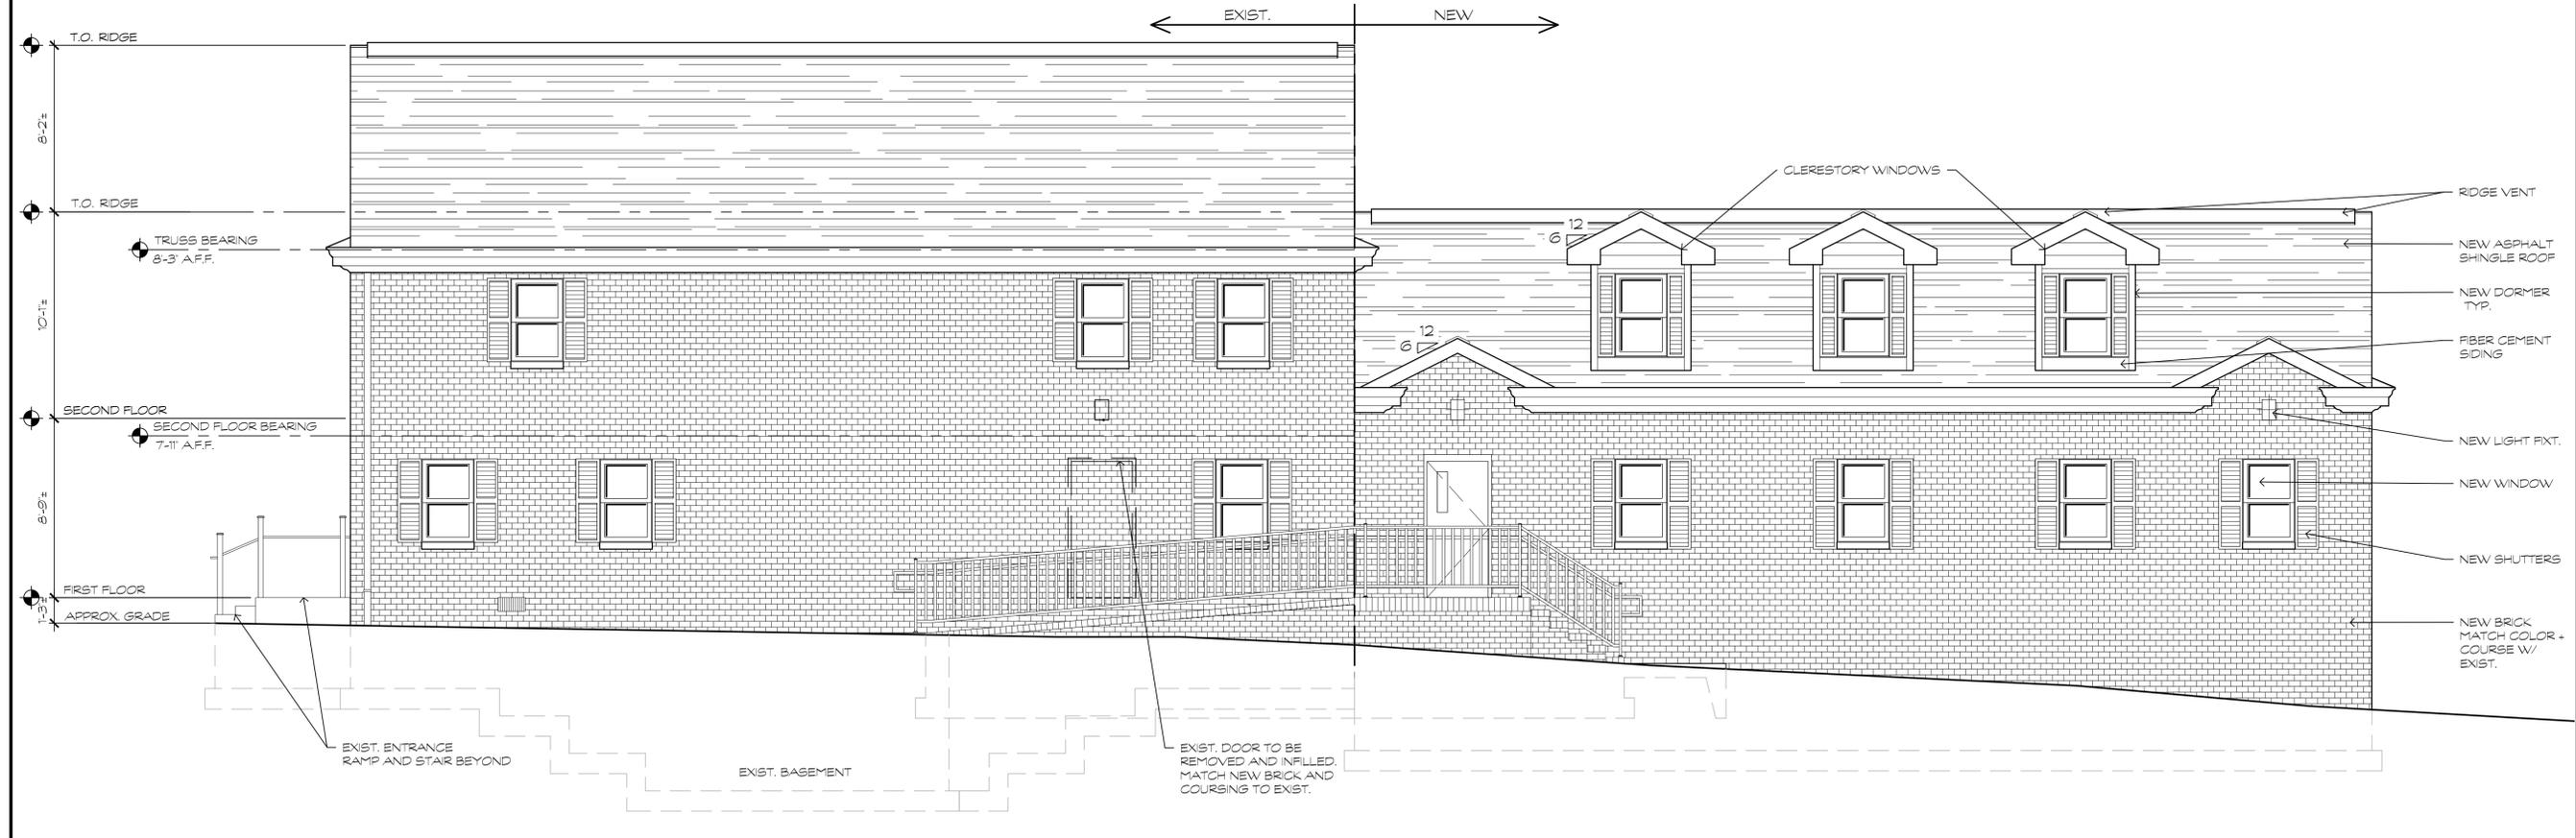

2 SOUTH ELEVATION  
1/4" = 1'-0"

DATE	02-09-2026
REVISION	ISSUED FOR PERMIT
NO.	1


**GMB**  
 GEORGE, MILES & BUHR, LLC  
 ARCHITECTS & ENGINEERS  
 SALESBURY • BALTIMORE • SEAFORD  
 www.gmbnet.com

FEASIBILITY STUDY FOR:  
**BRIDGEVILLE TOWN HALL**  
 101 N MAIN STREET BRIDGEVILLE, DE 19933

**PROPOSED  
 ELEVATIONS**

SCALE	:
DESIGN BY	:
DRAWN BY	:
CHECKED BY	:
GMB FILE	: 250281
DATE	:

A2.1

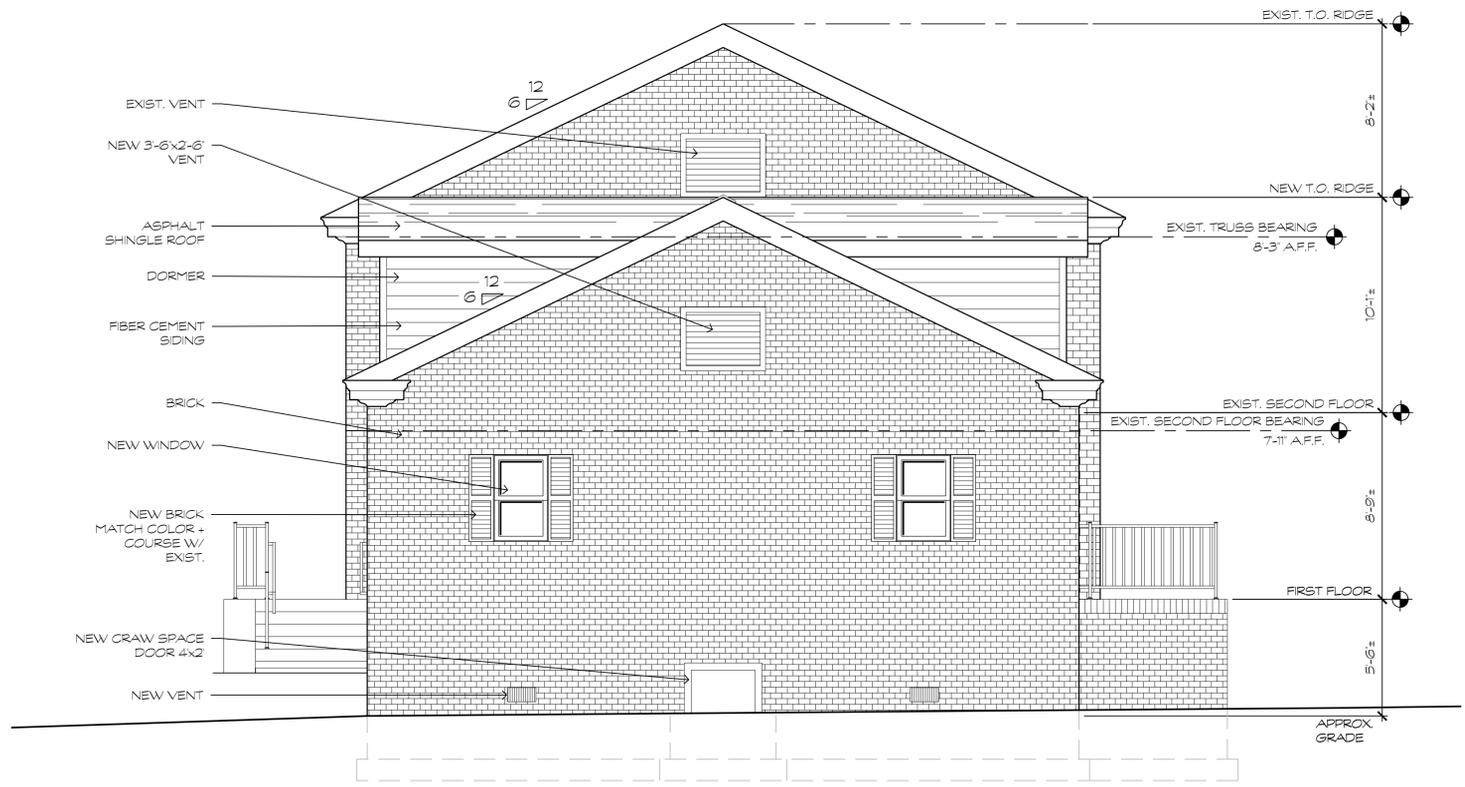

1

**EAST ELEVATION**  
1/4" = 1'-0"

NO.	1	REVISION	ISSUED FOR PERMIT	DATE	02-09-2026
 <b>GMB</b> GEORGE, MILES & BUHR, LLC ARCHITECTS & ENGINEERS SAUSURY • BALTIMORE • SEAFORD www.gmbnet.com					
FEASIBILITY STUDY FOR: <b>BRIDGEVILLE TOWN HALL</b> 101 N MAIN STREET BRIDGEVILLE, DE 19933					
<b>PROPOSED ELEVATIONS</b>					
SCALE : DESIGN BY : DRAWN BY : CHECKED BY : GMB FILE : 250281 DATE :					
<b>A2.2</b>					© COPYRIGHT 2025 GEORGE, MILES & BUHR, LLC